



MOUNTWEST COMMUNITY & TECHNICAL COLLEGE

HUNTINGTON, CABELL COUNTY, WEST VIRGINIA PARKING LOT A SLOPE REPAIR

CONTRACT NO. 2026-02

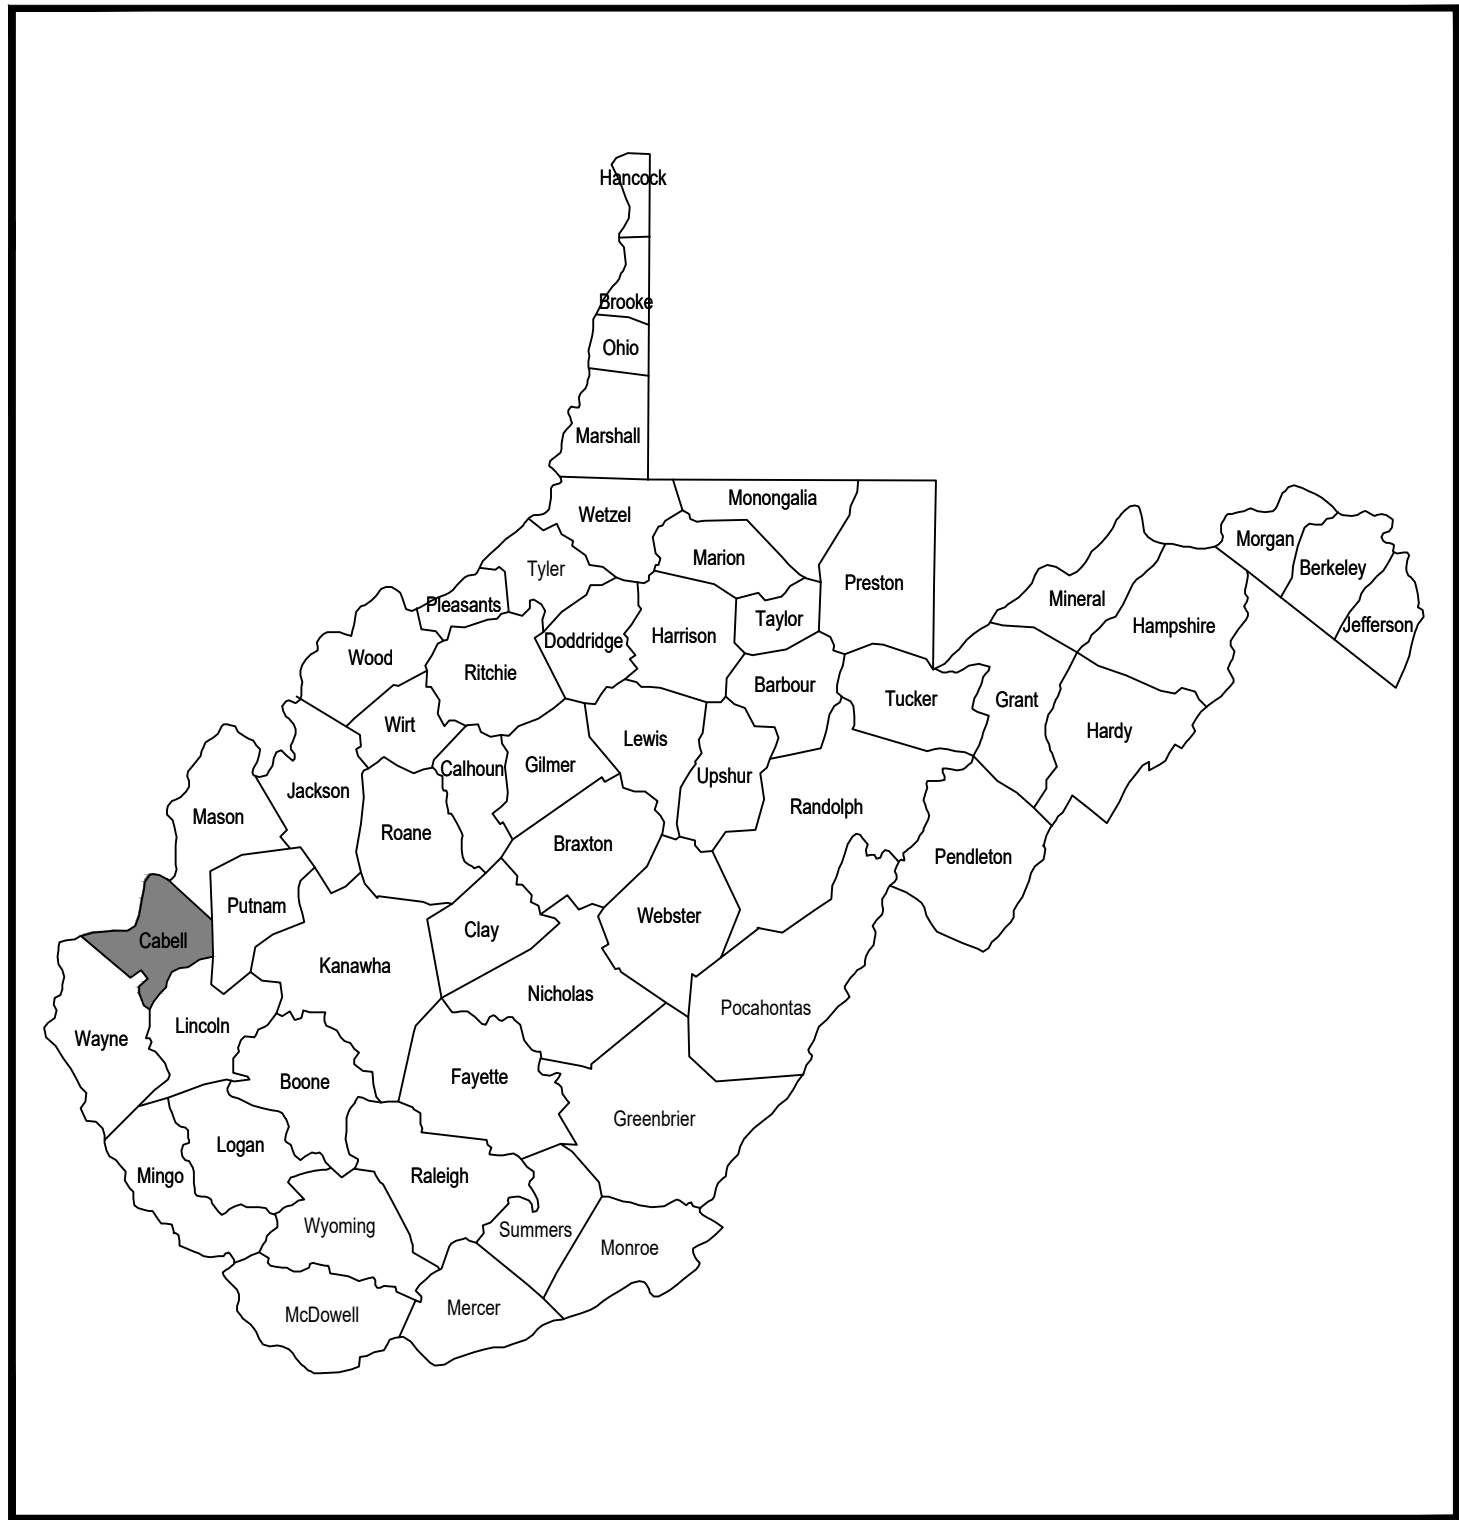

LOCATION MAP
NO SCALE

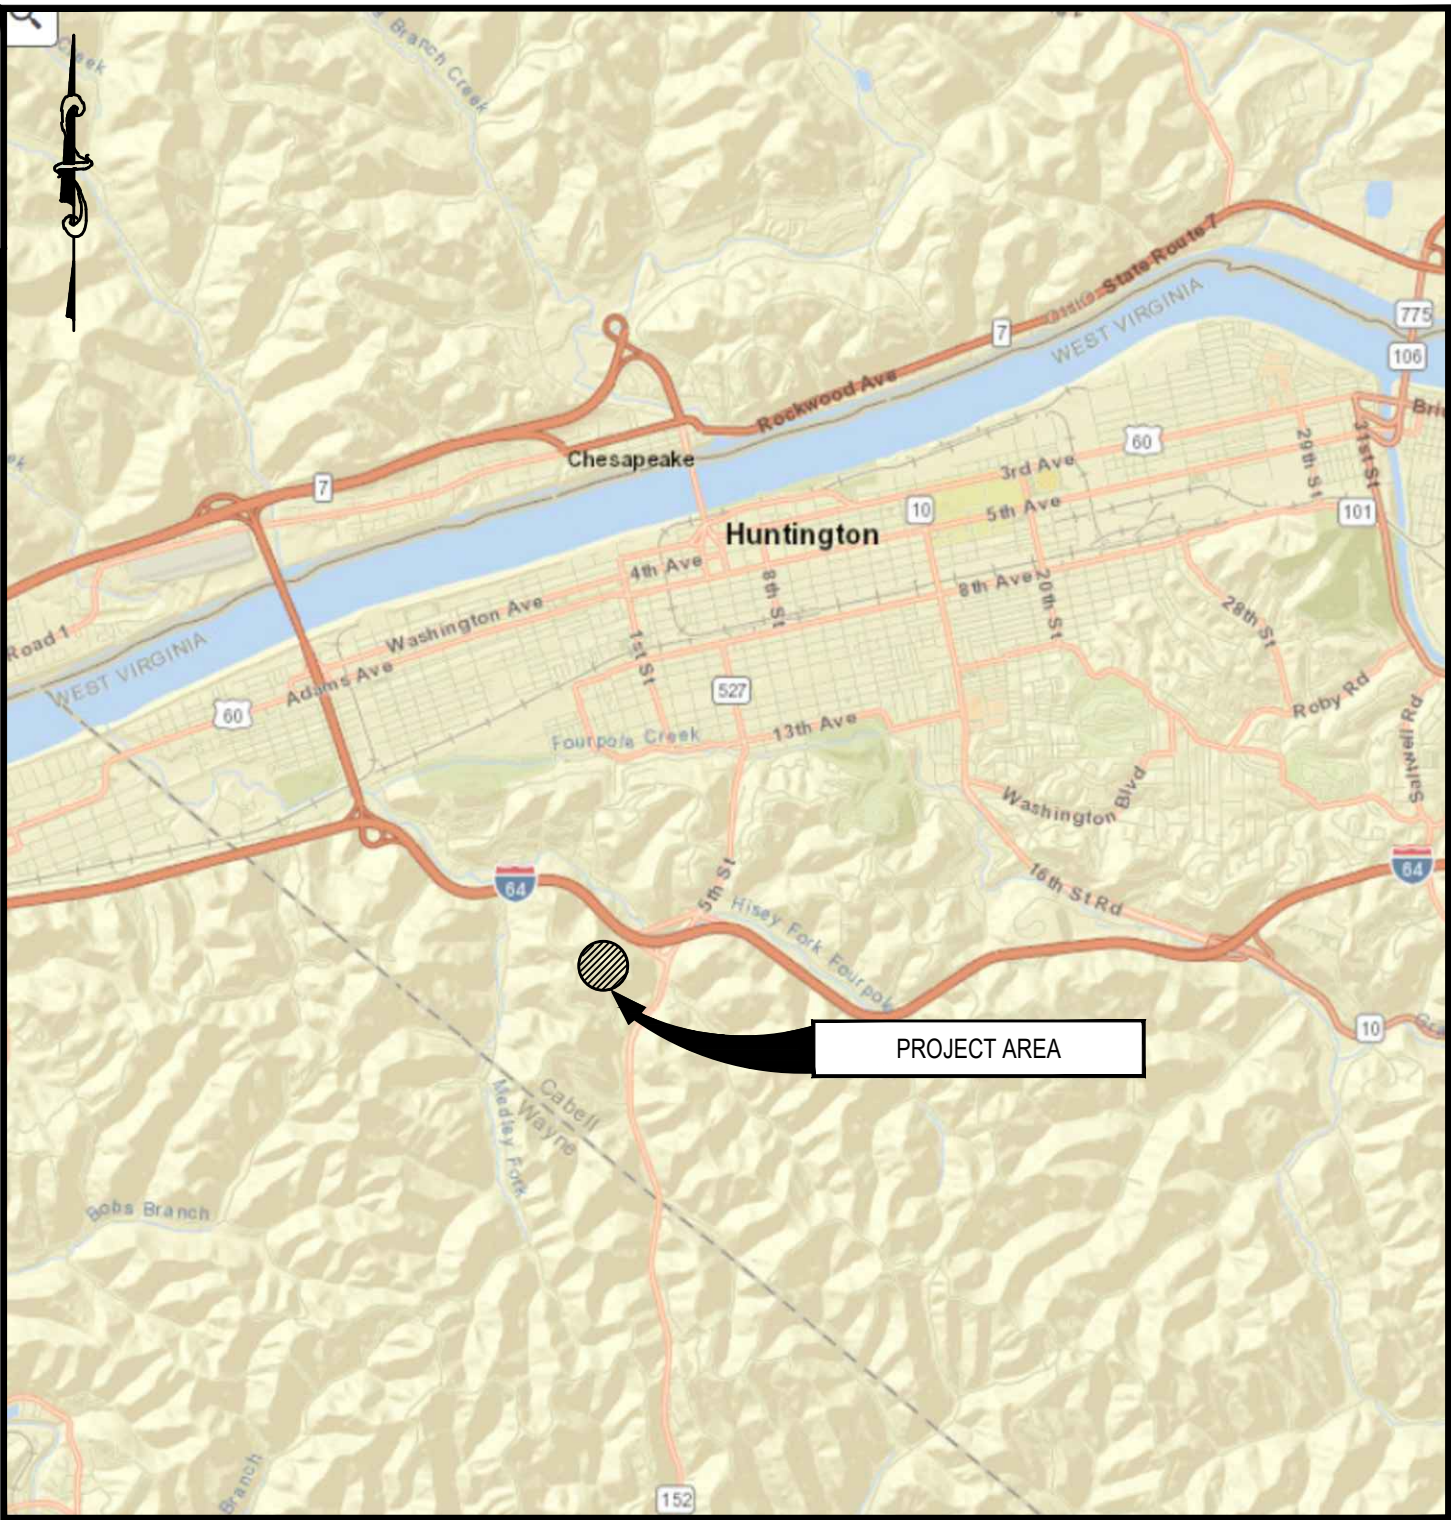

VICINITY MAP
NO SCALE

- DRAWING INDEX
- 1. TITLE SHEET
 - 2. EXISTING CONDITIONS
 - 3. H-PILE RETAINING WALL PLAN
 - 4. H-PILE RETAINING WALL SECTIONS
 - 5. H-PILE RETAINING WALL & DEADMAN ANCHOR DETAILS



STATUS:
FOR BID

BY

REVISIONS

NO

DATE

KANTI S. PATEL

DATE 02/26/2026

WEST VIRGINIA PROFESSIONAL ENGINEER 8628

MOUNTWEST COMM. & TECH. COLLEGE
HUNTINGTON, CABELL COUNTY, WEST VIRGINIA
PARKING LOT A DRAINAGE AND
SLOPE REPAIR
CONTRACT NO. 2026-02

TITLE SHEET

DRAWN	CHECKED	APPROVED	DATE	SCALE
RDJ	KSP	KSP	9/28/2026	AS SHOWN
DWG. NO.	C:\clients\documents\m\project\mountwest comm & tech college parking lot a drainage and			

SHEET NUMBER


1

OF 5

GENERAL NOTES

1. UTILITY FEATURES SHOWN HAVE BEEN LOCATED BY FIELD SURVEYS ON THE SURFACE. OVERHEAD AND UNDERGROUND LINES MAY DEFLECT BETWEEN SURFACE FEATURES. THE SURVEYOR MAKES NO GUARANTEE THAT THE UTILITIES SHOWN COMPRISE ALL SUCH UTILITIES IN THE AREA, EITHER IN SERVICE OR ABANDONED. THE SURVEYOR FURTHER DOES NOT WARRANT THAT THE UTILITIES SHOWN ARE IN THE EXACT LOCATION INDICATED. PRIOR TO ANY EXCAVATION IT IS THE RESPONSIBILITY OF THE OWNER AND/OR CONTRACTOR TO REQUEST THE UTILITY OWNERS TO PHYSICALLY LOCATE THE UNDERGROUND UTILITIES AND DETERMINE THEIR RIGHTS OF WAY/EASEMENTS OVER THE SUBJECT PROPERTY.

2. ALL DISTANCES ARE IN UNITS OF FEET UNLESS OTHERWISE NOTED


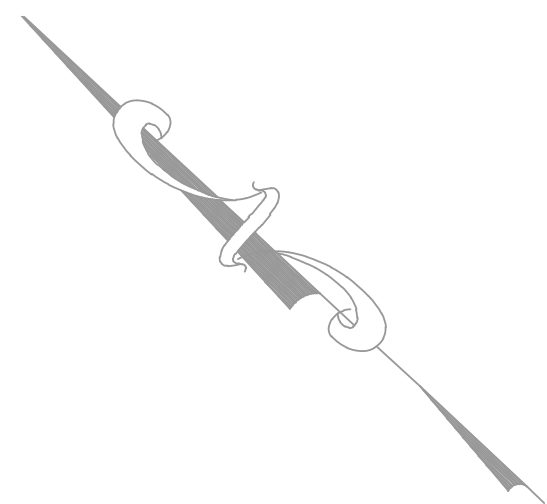


NORTH BASED UPON THREE (3)
CONTROL POINT BASE LINE WITH
THREE PHASES OF 60 SHOT
READINGS PERFORMED ON SITE
JULY 15TH 2026 GEOID18
PROJECTION NAD83 WV SOUTH
SCALE FACTOR 1:1.000193555

811 TICKET NUMBER: 2619487105
SUBMITTED 7/13/2026 2:20:59 PM

UTILITIES LISTED

 SEGRA STOCK
Segra
Mountaineer Gas Company
Diversified Gas & Oil
Huntington Sanitary Board
American Electric Power Company
Comcast Cable Company
West Virginia American Water Company

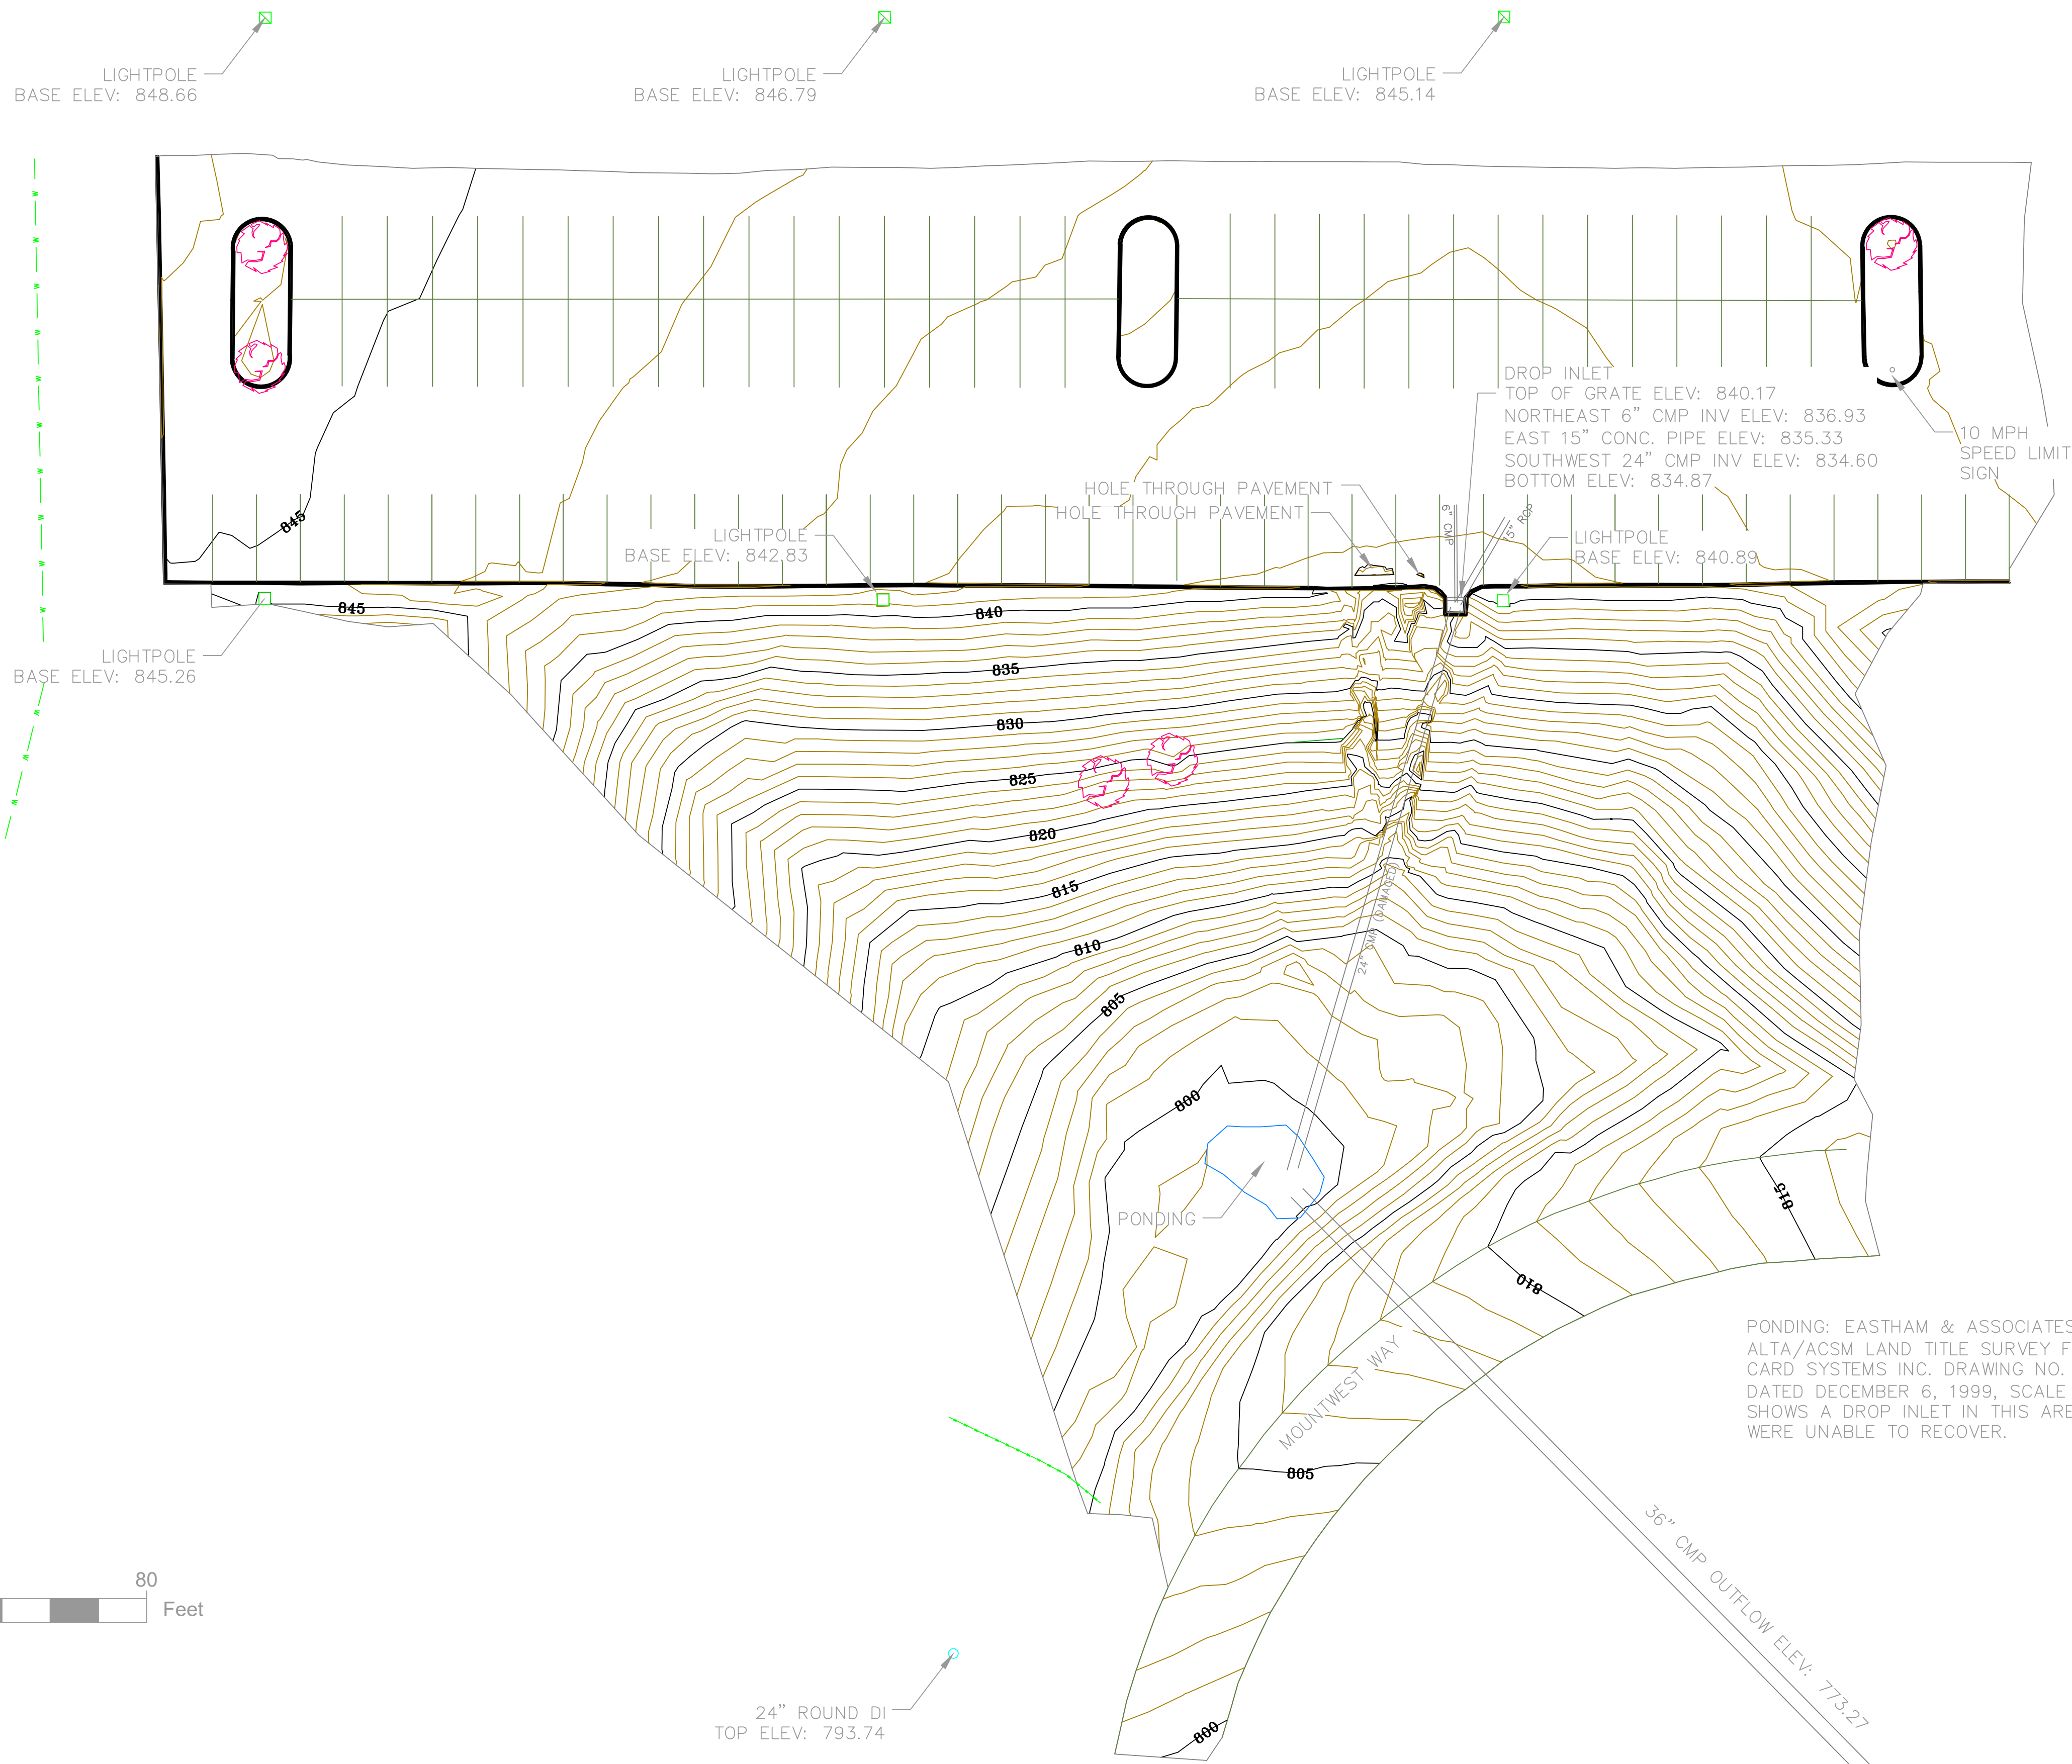

PONDING: EASTHAM & ASSOCIATES PERFORMED AN ALTA/ACSM LAND TITLE SURVEY FOR APPLIED CARD SYSTEMS INC. DRAWING NO. 8543 DATED DECEMBER 6, 1999, SCALE 1"=100' THAT SHOWS A DROP INLET IN THIS AREA THAT WE WERE UNABLE TO RECOVER.

LEGEND:

- | | |
|----------|-----------------------------|
| | PROPERTY CORNER |
| | PROPERTY LINE |
| | RIGHT OF WAY LINE |
| POB | POINT OF BEGINNING |
| | TELEPHONE UNDERGROUND |
| -E-T-U- | ELECTRIC, PHONE, TELEVISION |
| -W- | WATER |
| -SS- | SANITARY SEWER |
| | CLEANOUT |
| ST | STORM SEWER |
| -GAS- | GAS |
| | STREET SIGN |
| | WATER METER |
| | WATER VALVE |
| | GAS VALVE |
| | GAS METER |
| (XX"XX") | RECORD CALL |
| | UTILITY POLE |
| | UTILITY UNDERGROUND |
| | AREA LIGHT |
| | GAS MARKER |
| EP | EDGE OF PAVEMENT |
| | TEMPORARY BENCH MARK |
| | BOREHOLE LOCATION |
| | TAX MAP |
| | TAX PARCEL |
| | MANHOLE |
| | LOT LIGHTS |
| | FIRE HYDRANT |
| | SURVEY CONTROL |
| | TRAFFIC DIRECTION |
| | TEMP CONSTRUCTION FENCE |
| | SILT FENCE |
| | DRAINAGE ARROW |
| | DROP INLET |



S:
BID

KANTI S. PATEL

DATE 9/28/2026
WEST VIRGINIA PROFESSIONAL ENGINEER 9628



AMOUNTWEST COMM. & TECH. COLLEGE
HUNTINGTON, CABELL COUNTY, WEST VIRGINIA
**PARKING LOT A DRAINAGE AND
SLOPE REPAIR**
CONTRACT NO. 2026-02

EXISTING CONDITIONS

SHEET NUMBER

2

OF 5

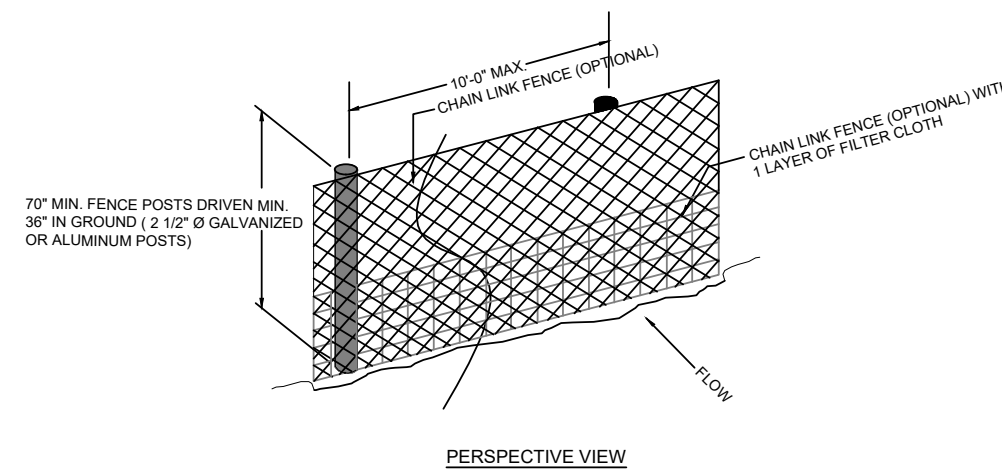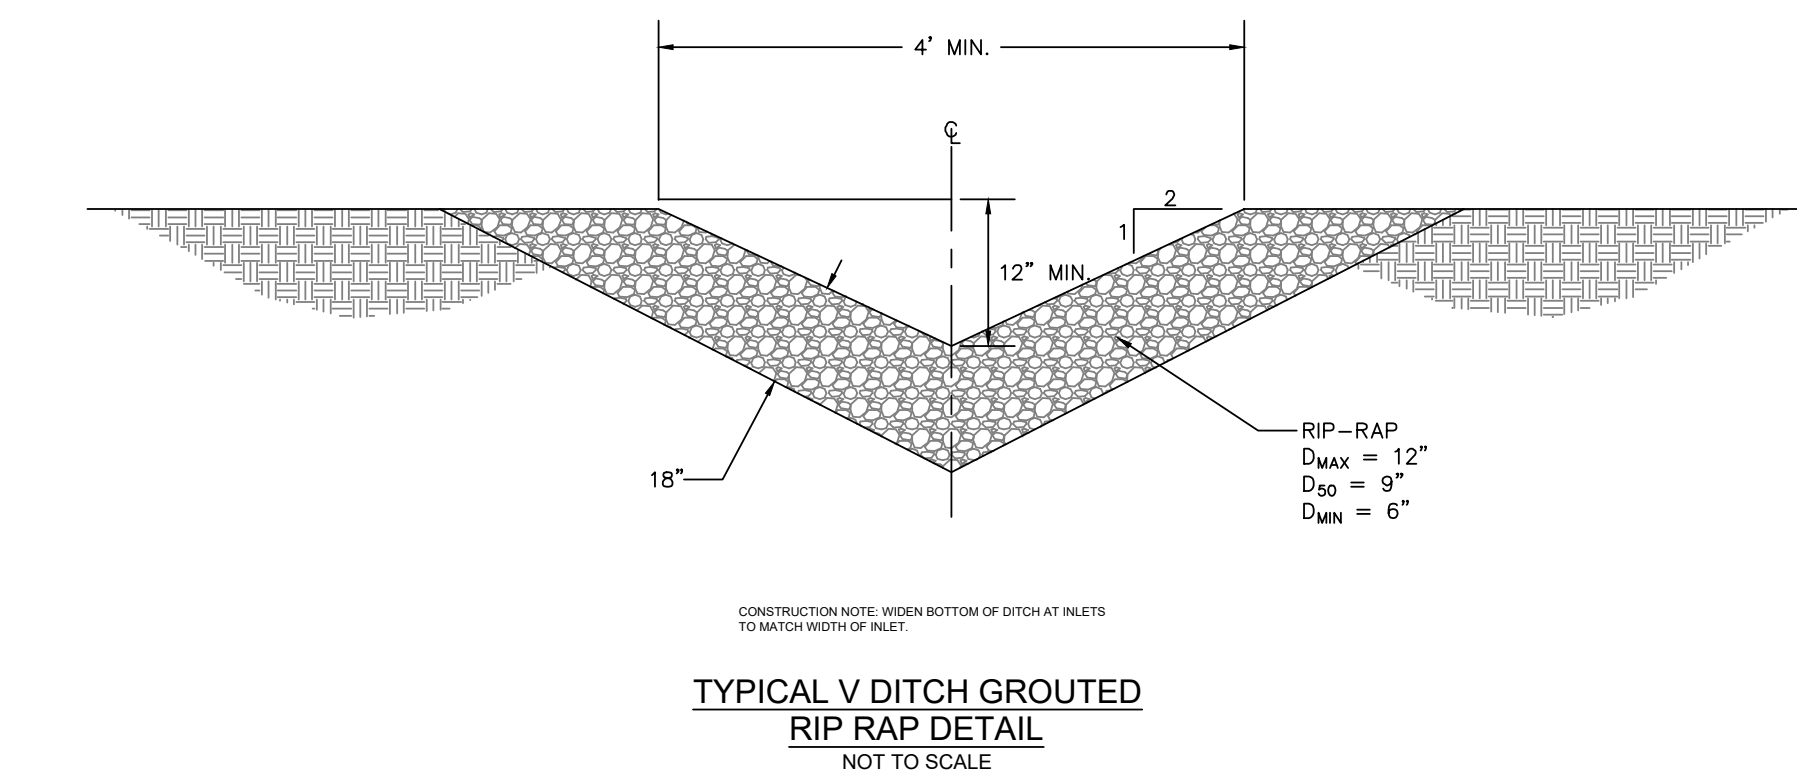




SUPER SILT FENCE DETAIL
NOT TO SCALE

[illegible]

to let a slope and well

DRAWN	CHECKED	APPROVED	DATE	SCALE
RDJ	KSP	KSP	9/28/2026	AS SHOWN

OF 5

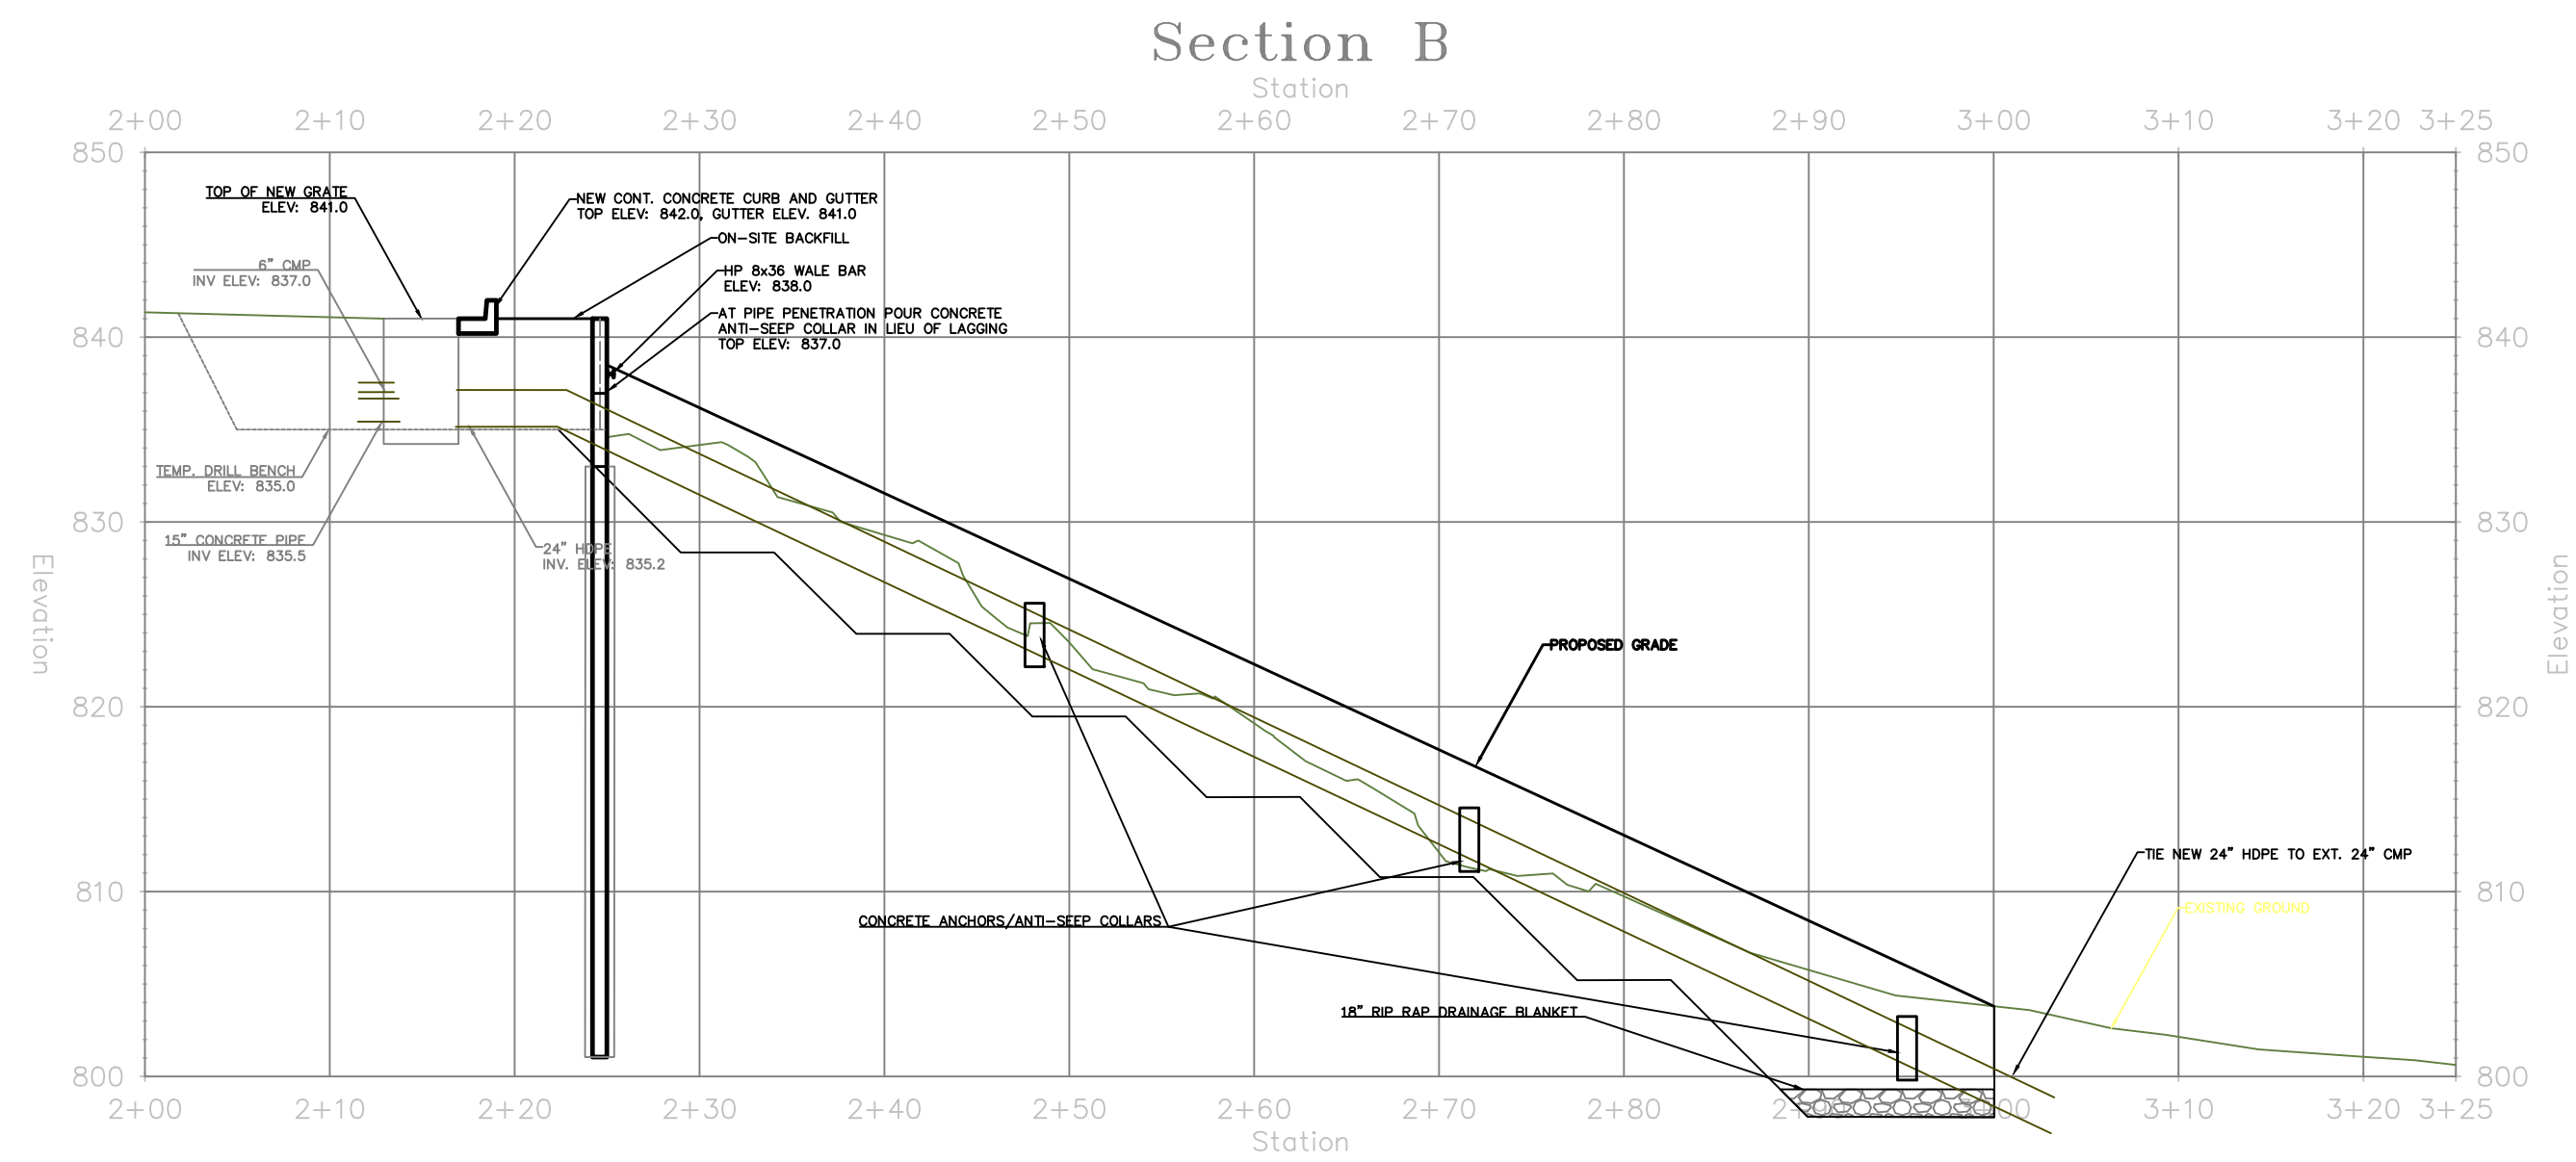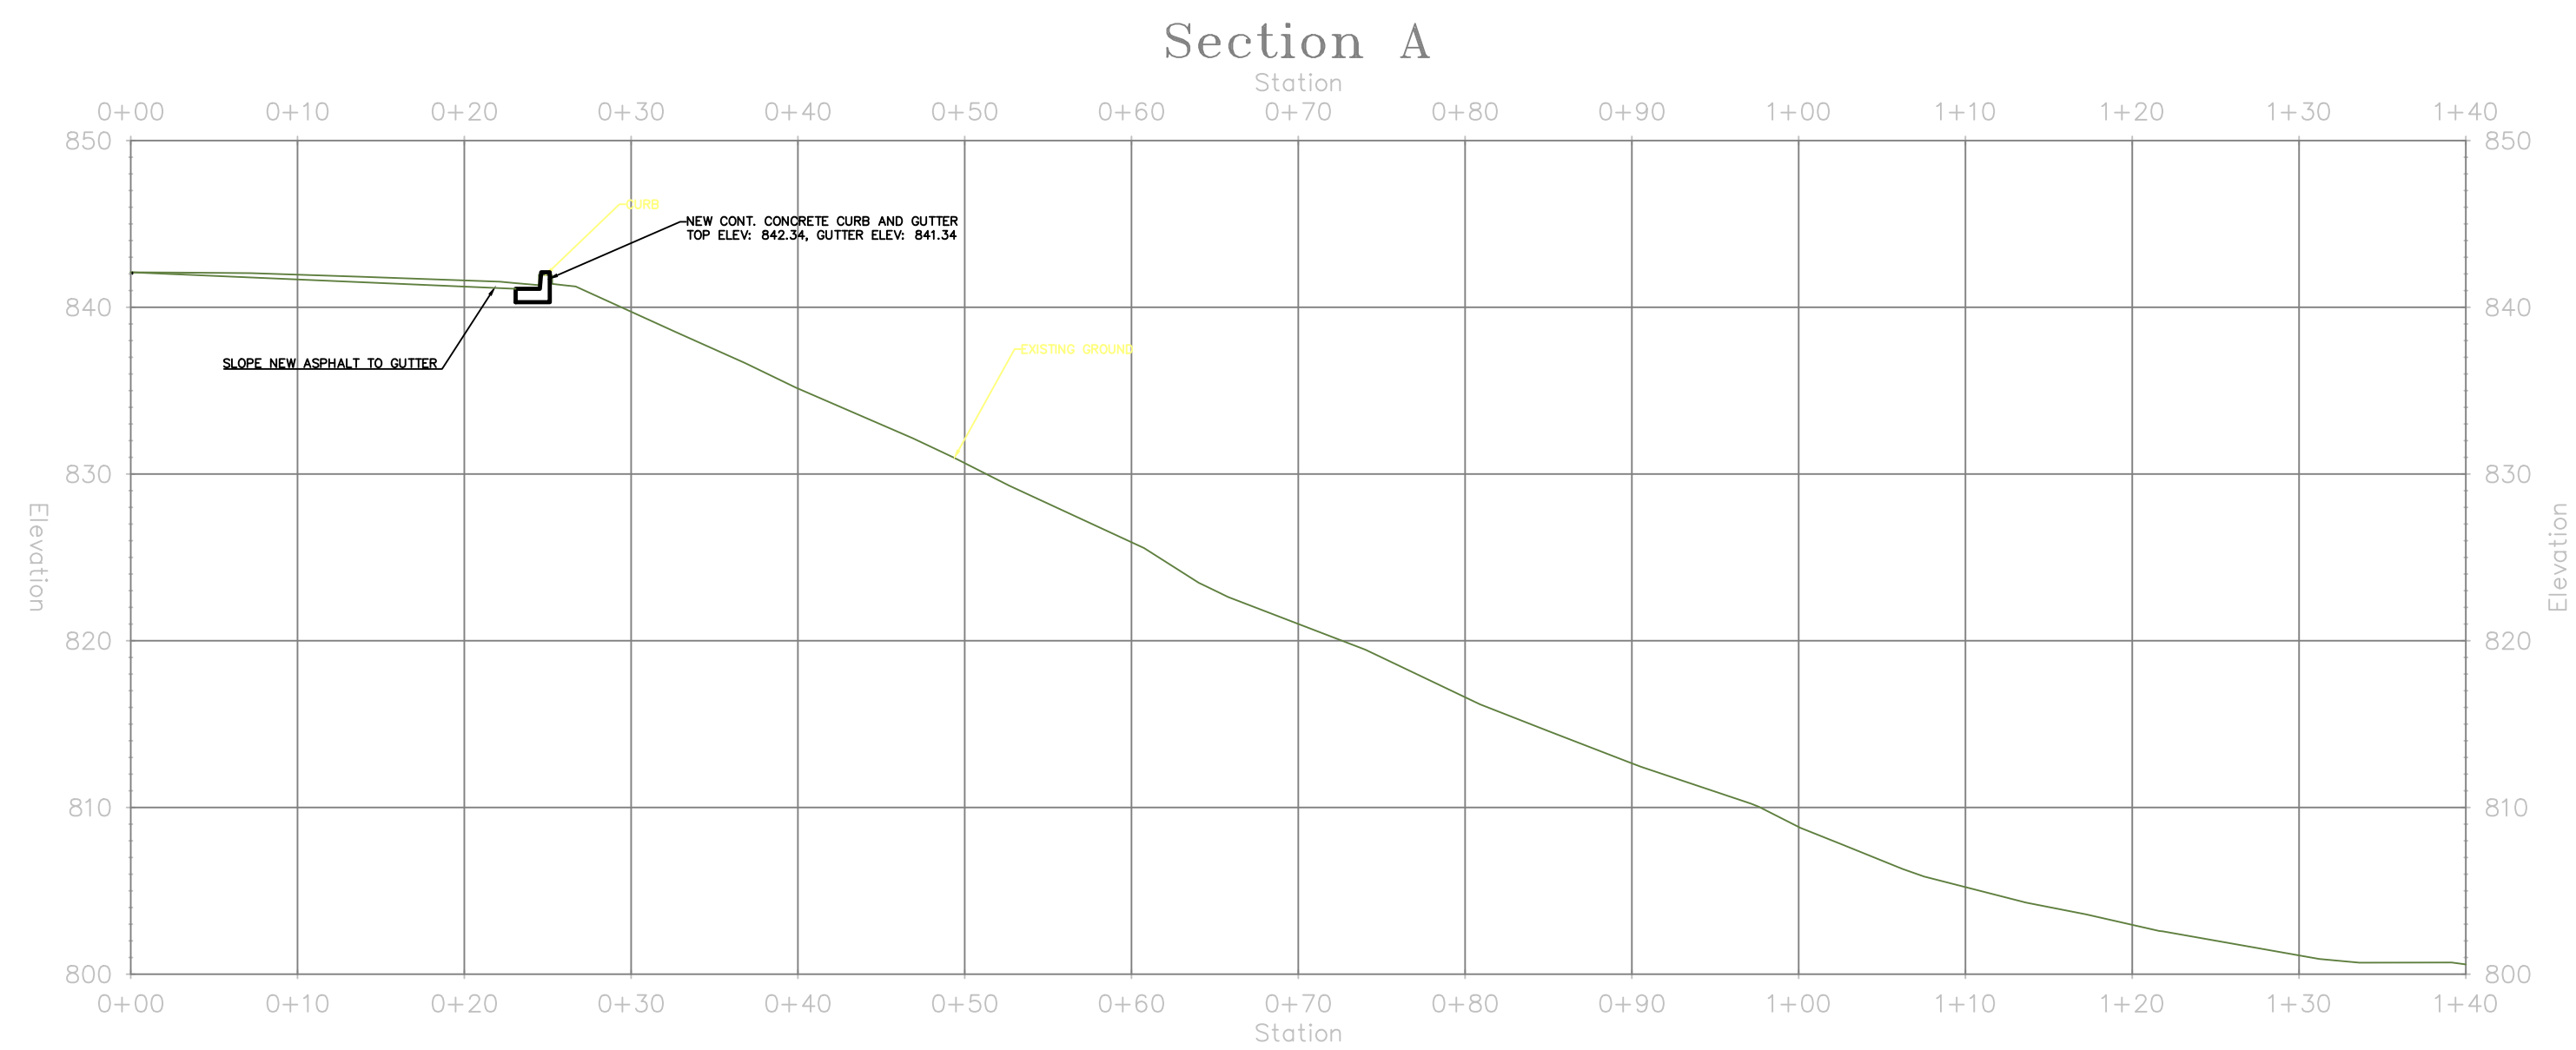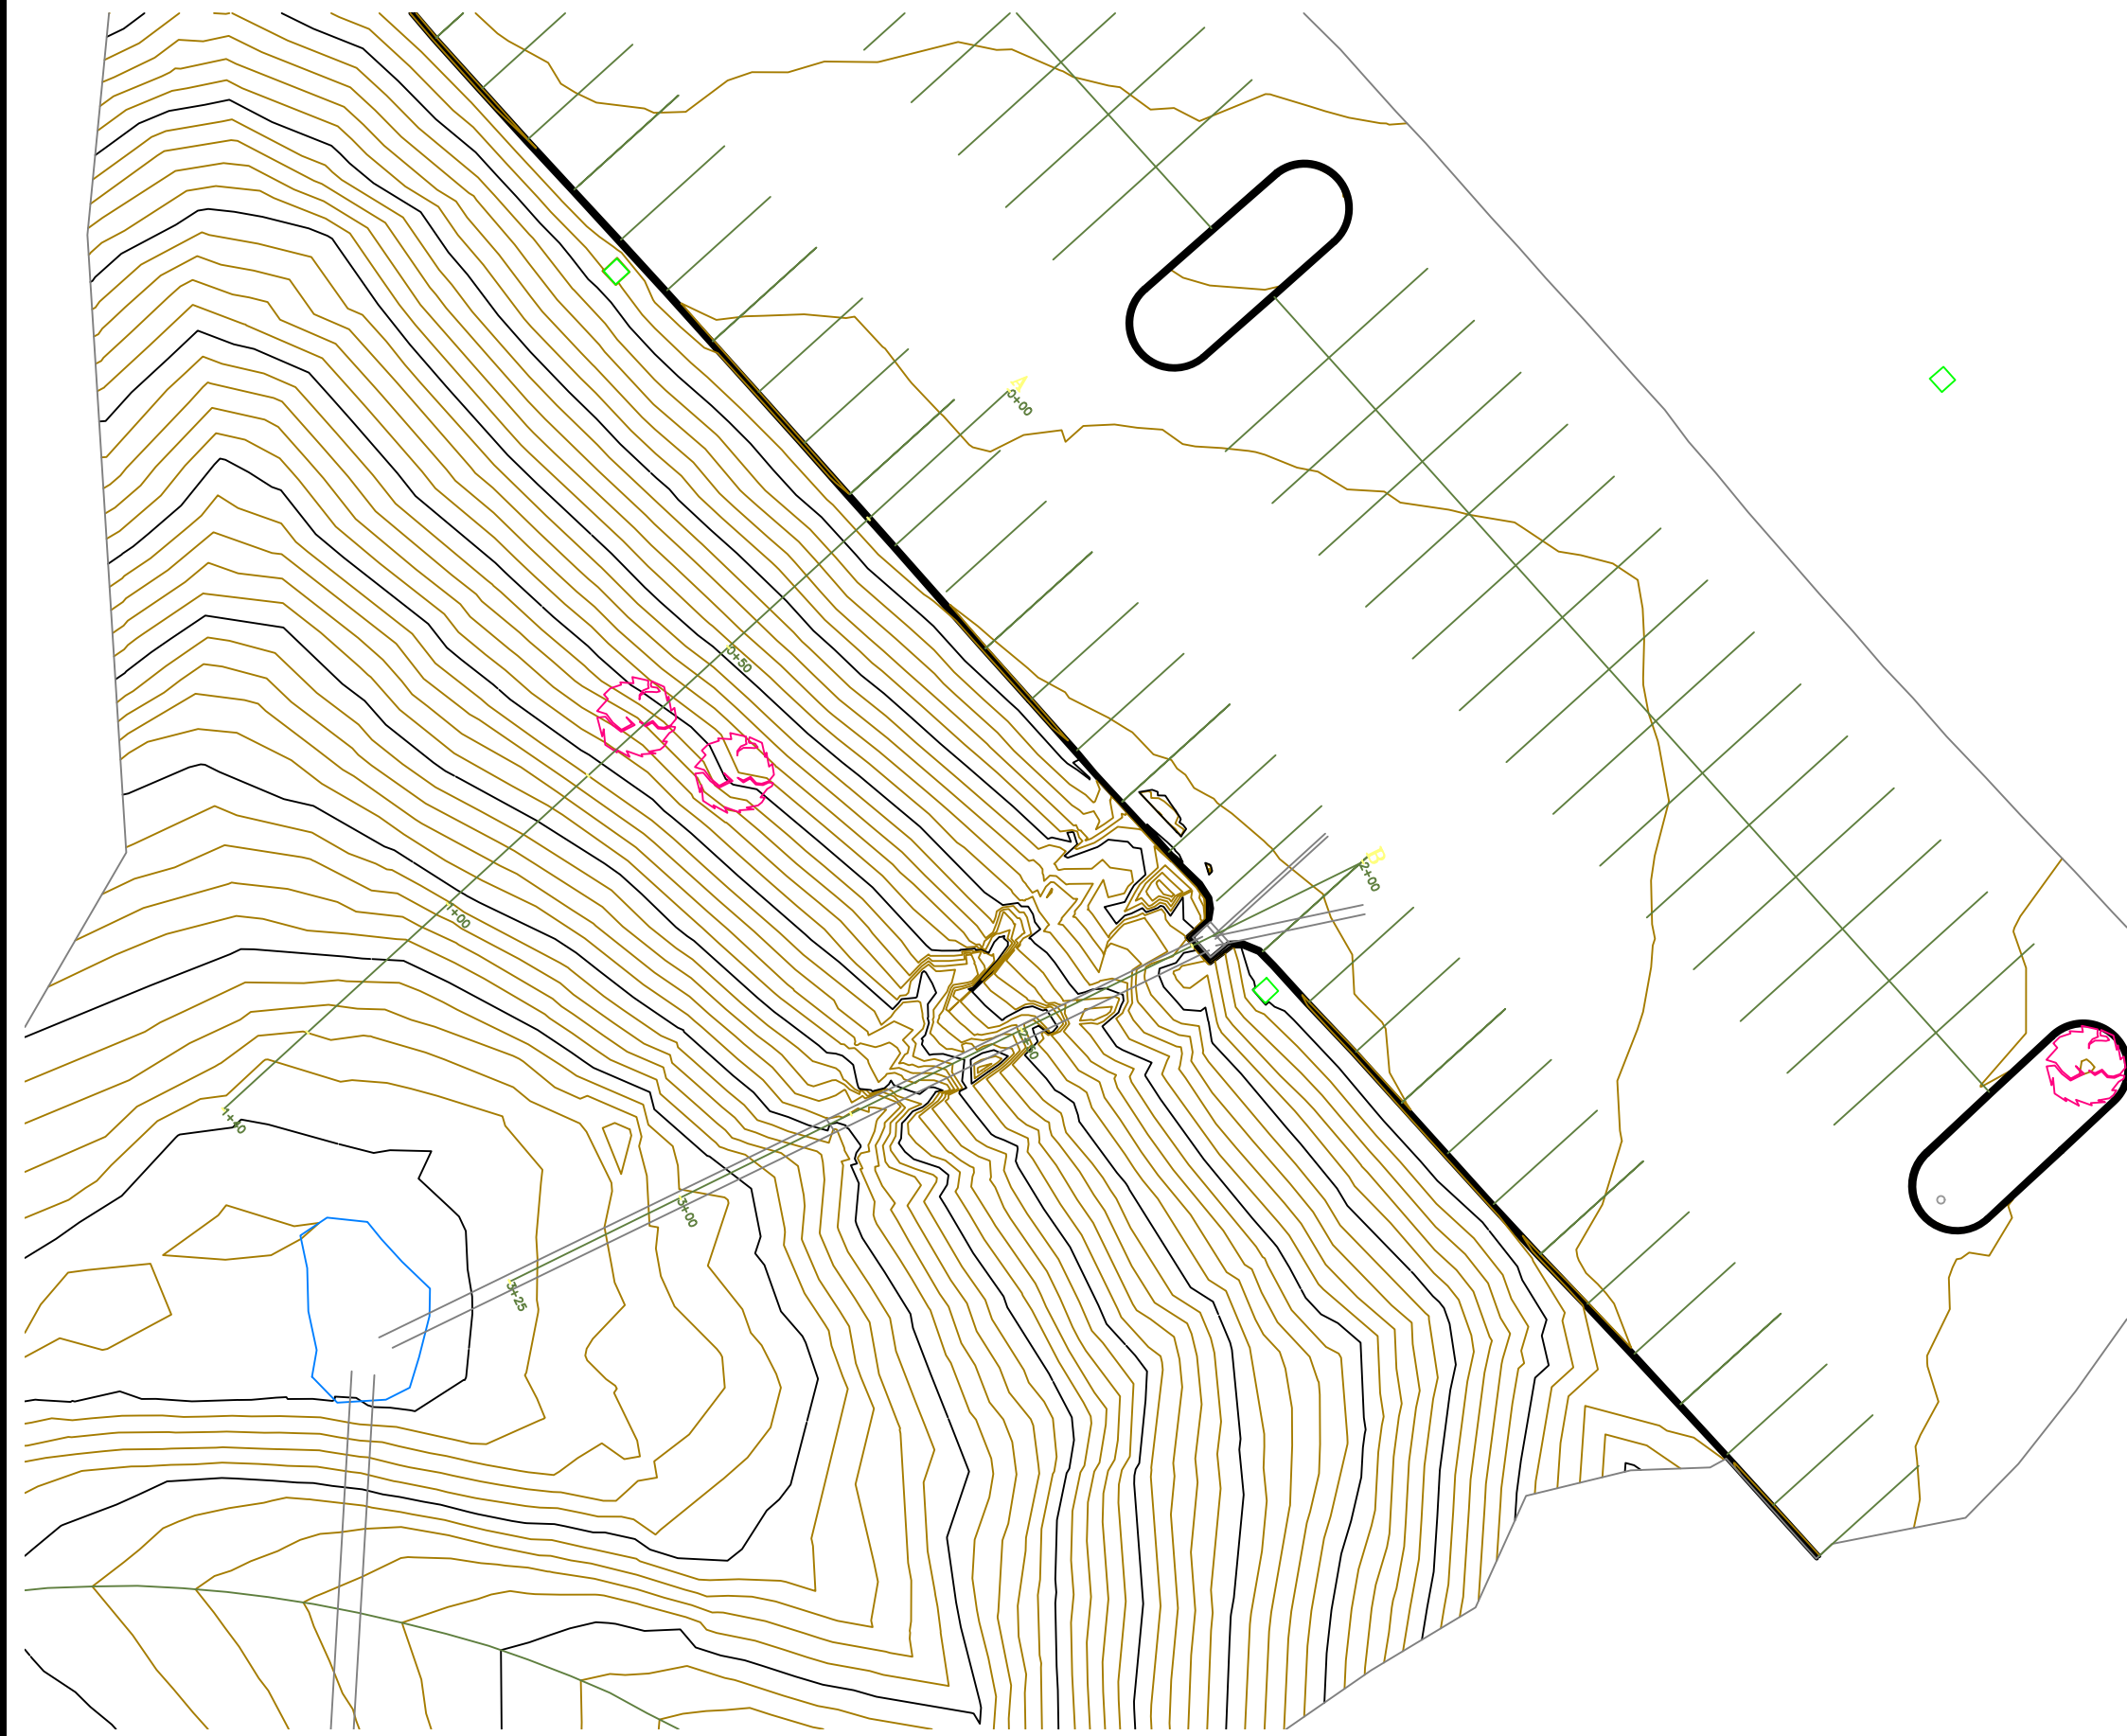

CROSS SECTIONS
HORIZ: 1"=10'
VERT: 1"=10'



STATUS:
FOR BID

BY

REVISIONS

NO. DATE

KANTI S. PATEL

DATE 9/22/2026

WEST VIRGINIA PROFESSIONAL ENGINEER 8628

MOUNTWEST COMM & TECH. COLLEGE
HUNTINGTON, CABELL COUNTY, WEST VIRGINIA
PARKING LOT A DRAINAGE AND
SLOPE REPAIR
CONTRACT NO. 2026-02


H-PILE RETAINING WALL SECTIONS

DRAWN	CHECKED	APPROVED	DATE	SCALE
RDJ	KSP	KSP	9/22/2026	AS SHOWN
DWG. NO.	C:\Users\jacob\Documents\project\mountwest comm & tech\collage parking lot a\dwg\dwg 04.dwg			

SHEET NUMBER

4

 OF 5



STATUS:

KANTI S. PATEL

DATE 9/28/2026 WEST VIRGINIA PROFESSIONAL ENGINEER 0628

MOUNTAINVIEW COMM. & TECH. COLLEGE
 HUNTINGTON, CABELL COUNTY, WEST VIRGINIA
 PARKING LOT A DRAINAGE AND
 SLOPE REPAIR
 CONTRACT NO. 2006-02

H-PILE RETAINING WALL & DEADMAN ANCHOR DETAILS

SHEET NUMBER

5

OF 5